

KEYNOTES

- 15 109 PROVIDE 3/4" CPVC FEMALE NPT VALVES SERVING DISPENSER AND GROCERY EQUIPMENT. PROVIDE 3/4" PEK LINE FOR TEMPORARY BYPASS BETWEEN BUILDING WATER SUPPLY LINE AND RO WATER LINE SERVING GROCERY EQUIPMENT. REMOVE BYPASS AFTER STARTUP AND TESTING OF GROCERY EQUIPMENT.
- 15 127 INSTALL BRANCH LINE CONNECTION FITTING WITH INLET ROTATED UP 15° MINIMUM ABOVE HORIZONTAL TO PREVENT BACKFLOW. REFER TO DWV BRANCH CONNECTION DOWNSTREAM OF TOILET DETAIL.

STIPULATION FOR THE CONTRACTOR TO VERIFY THE EXISTING CONDITIONS AND TO BE RESPONSIBLE FOR THE ACCURACY OF THE INFORMATION PROVIDED. THE CONTRACTOR SHALL BE RESPONSIBLE FOR OBTAINING ALL NECESSARY PERMITS AND FOR THE PROTECTION OF ALL EXISTING UTILITIES. THE CONTRACTOR SHALL BE RESPONSIBLE FOR THE PROTECTION OF ALL EXISTING UTILITIES. THE CONTRACTOR SHALL BE RESPONSIBLE FOR THE PROTECTION OF ALL EXISTING UTILITIES.

MPW
 PIPE ENGINEERING, LLC
 1100 S. UNIVERSITY AVENUE, SUITE 100
 APOPKA, FL 32703
 (407) 881-1100

Walmart
 APOKA, FL
 STORE NO. 0884
 JOB NUMBER: 09715-006 | PHOTO

ISSUE BLOCK

▲	02/20/17	REV #2
▲	03/10/17	REV #3
▲	04/07/17	REV #5


CHECKED BY: MAM
 DRAWN BY: TDT
 FILE NAME: P4
 PROTO CYCLE: 10/28/16
 DOCUMENT DATE: 01/09/17

**BID SET
 NOT FOR
 CONSTRUCTION**


THIS ITEM HAS BEEN ELECTRONICALLY SIGNED AND SEALED BY SCOTT C. WEBB. PE ON THE DATE AND/OR TIME STAMP SHOWN USING A DIGITAL SIGNATURE. PRINTED COPIES OF THIS DOCUMENT ARE NOT CONSIDERED SIGNED AND SEALED AND THE SIGNATURES MUST BE VERIFIED ON ANY ELECTRONIC COPIES.

PLUMBING RISERS


SHEET: **P4**

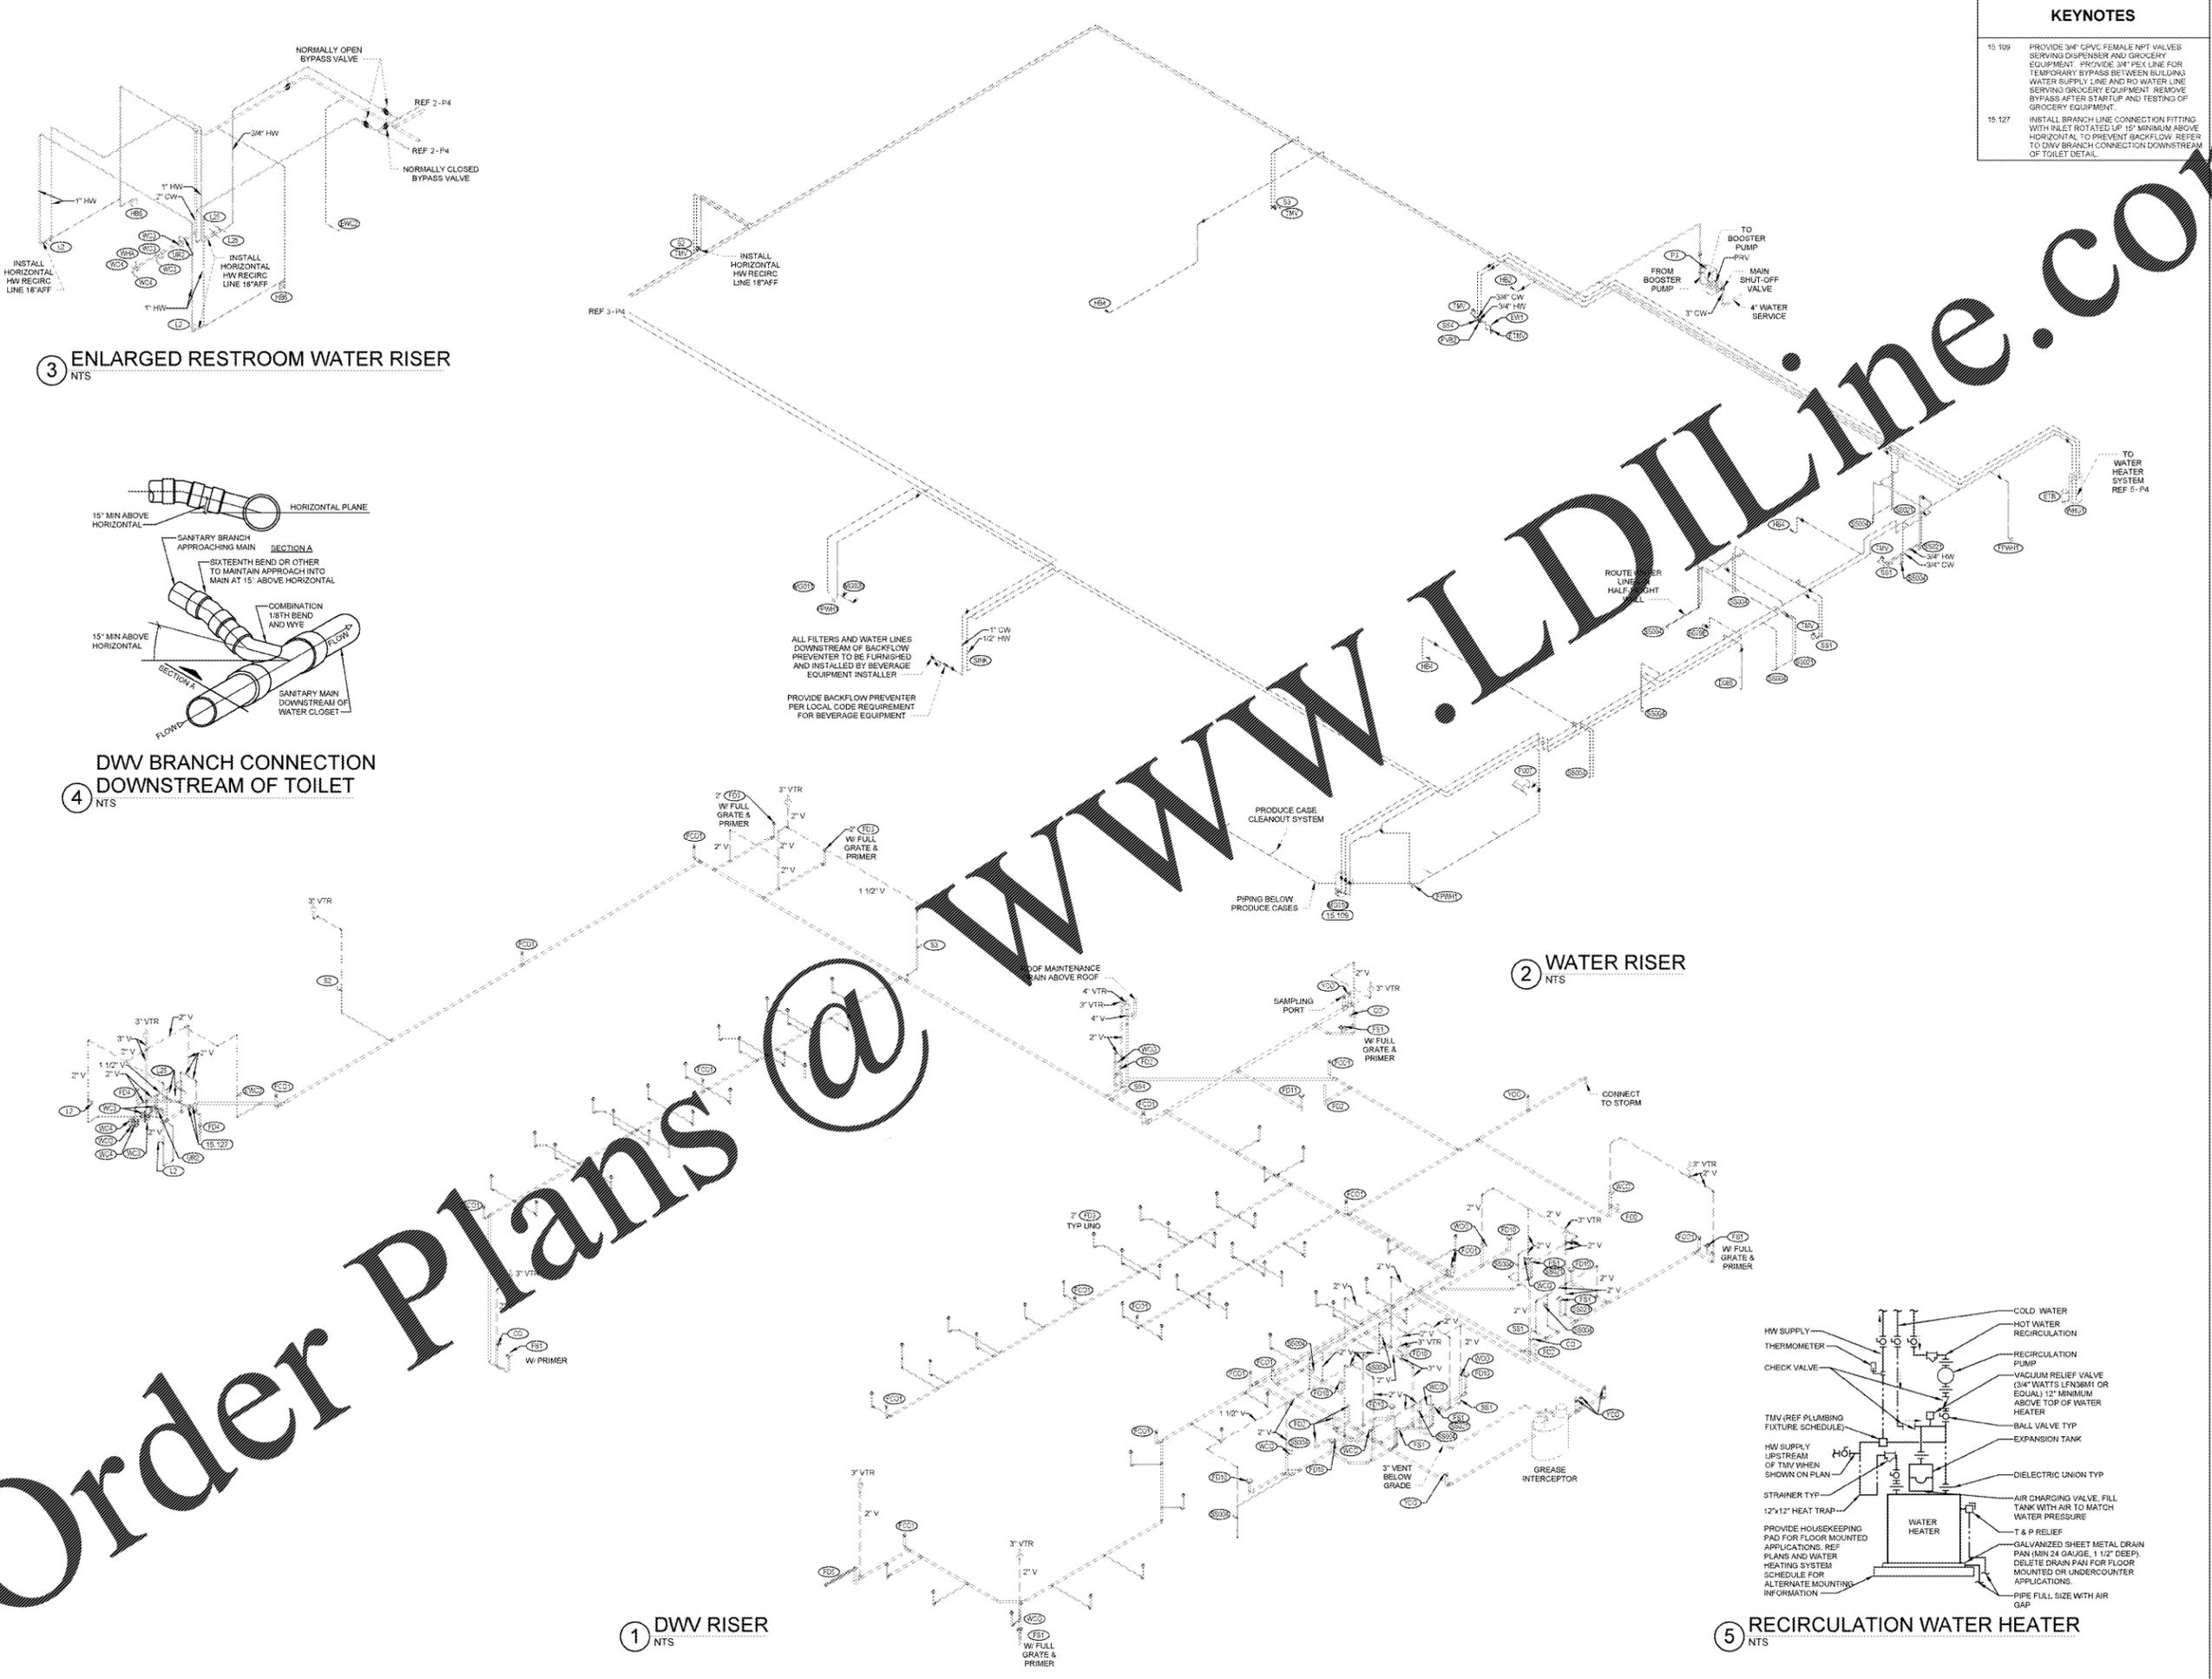

3 ENLARGED RESTROOM WATER RISER
 NTS

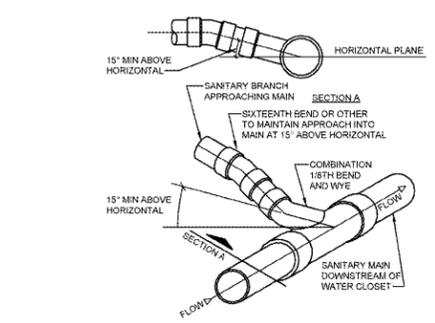


4 DWV BRANCH CONNECTION DOWNSTREAM OF TOILET
 NTS

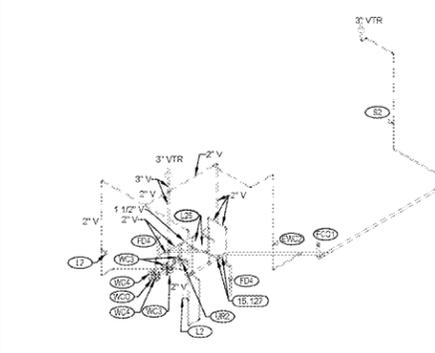

1 DWV RISER
 NTS

2 WATER RISER
 NTS

5 RECIRCULATION WATER HEATER
 NTS

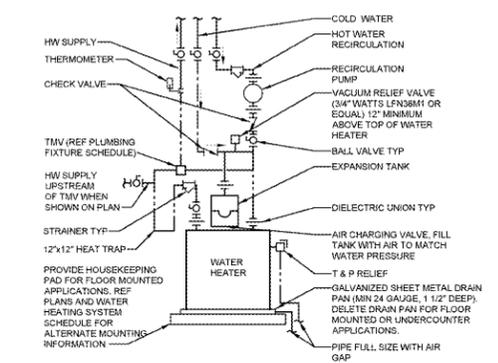

Order Plans @