## NATIONAL ACCOUNTS: SWITCHGEAR SUPPLY and INSTALL STANDARD PACKAGE

CORPORATE AND FRANCHISE DEVELOPMENT


YUM NATIONAL ACCOUNT AGREEMENT IS WITH SQUARE-D FOR ELECTRICAL SWITCHGEAR EQUIPMENT FOR COMPANY AND FRANCHISE DEVELOPMENT. CUTLER-HAMMER ELECTRICAL SWITCHGEAR EQUIPMENT IS AN APPROVED ALTERNATE MANUFACTURER FOR FRANCHISE DEVELOPMENT ONLY.


UNDER THIS AGREEMENT, THE CONTRACTOR IS RESPONSIBLE FOR PROFINED AND INSTALLATION OF THE SYSTEMS DESCRIBED IN THE PLANS. ALL COMPANY AND FRANCHISE PROJECTS SHALL CONTRACT ACCUSERVE FOR A PRICE QUOTE AND A BILL OF MATERIAL CONFIRMATION FOR THEIR SPECIFIC PROJECT. SEE THE SWITCHGEAR SECTION IN THE SCOPE OF WORK FOR ADDITIONAL INFORMATION.

PRIMARY CONTACT: BUDDY BOCKWEG PHONE: (877) 707-7378 FAX: (502) 961-0357 EMAIL: buddy@accuserv.com

THE SWITCHGEAR PACKAGE CONSISTS OF SERVICE ENTRANCE, SWITCHGEAR, MAIN PANELS, SUB PANELS, LIGHTING CONTACTORS AND ALL ASSOCIATED PRODUCTS TO COMPLIMENT THE SWITCHGEAR PACKAGE.

BE PREPARED AT TIME OF ORDER OR QUOTE REQUEST TO PROVIDE ALL PROJECT DETAILS REGARDING SPECIFICATIONS AND QUANTITIES AS SITE SPECIFIC DESIGN MAY NOT MATCH PROTOTYPICAL DESIGN.

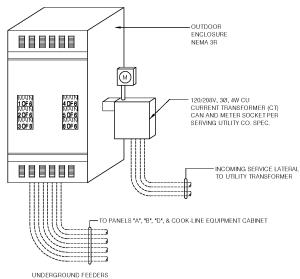

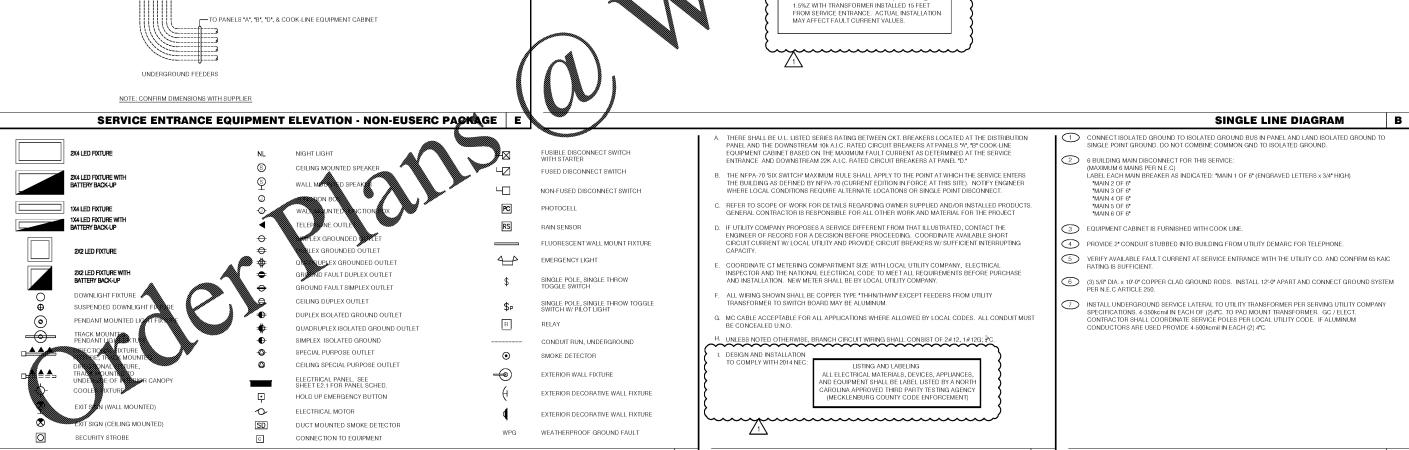

F

CONCRETE ENCASED

ENCASED REBAR

CADWELD EXOTHERMIC

(MIN. 20'-0")

"MSB" GND BUS

**ELECTRICAL LEGEND** 

ROUND

3/4°C-1 #2/0 CU BOND TO -

3/4"C-1 #2/0 CU GND

4 TO LOCAL PHONE SERVICE

BEBAR



INSTALL 120/208V/3Ø/4W/600A, CURRENT TRANSFORMER (CT) CAN AND METER SOCKET PER SERVING -

ALL PANELBOARDS AND ELECTRICAL EQUIPMENT SHALL BE LABELED WITH ARC FLASH HAZARD WARNING PER NEC 110.16.

UTILITY COMPANY SPECIFICATIONS

-5

2)2<u>400AT</u>

2

**GENERAL NOTES** 

1 #2/0 CU EQUIP. BOND

2  $\frac{150AT}{2D}$ 

CU 65KAIC FULLY RATED

FAULT CURRENT VALUES ARE BASE ON PAD MOUNTED UTILITY TRANSFORMER, 112.5KVA @

 $2^{200AT}$ 

ATLANTA - CHARLOTTE - GREEWILLE - RICHMON Devits & Sascietes, Inc. 1909cf. 1, 1900-22 Drawn by REP. Checked by RAG.

SERVICE SHALL BE 600 AMP, 120/208V,

**KEY NOTES** 

C



12144.400

	12144.400
	A ELECTRICAL COMMENTS 11/17/201
	Δ
	$\overline{\triangle}$
	$\Delta$
-	$\Delta$

BUILDING TYPE: EXP. LITE MED40
PLAN VERSION: DECEMBER 2016
SITE NUMBER: 311687
STORE NUMBER: 436563

CONTRACT DATE:

TACO BELL

3923 SHAKEDOWN ST CHARLOTTE, NC



RISER DIAGRAM AND LEGEND

E A A

E2.0