

Architect:  
 archSTUDIO7, PLLC  
 301 N. MAIN STREET, SUITE 1201  
 Winston-Salem, NC 27101  
 Tel. 336.793.9900  
 www.archstudio7.com  
 Copyright Reserved

The Contractor shall verify and be responsible for all dimensions. DO NOT scale the drawing - any errors or omissions shall be reported to archSTUDIO7, PLLC without delay. The Copyright to all designs and drawings are the property of archSTUDIO7, PLLC. Reproduction or use for any purpose other than that authorized by archSTUDIO7, PLLC is forbidden.

Consultants:



WAVE ENGINEERING  
 1300 N. MINT ST., SUITE 110  
 CHARLOTTE, NC 28203  
 INFO@WAVEENGINEERING.COM  
 NC CORP. LICENSE #R-1621  
 WAVE PROJECT #201-20

Permit - Seal:

PRELIMINARY  
 NOT FOR CONSTRUCTION  
 OR PRICING

10/20/2020

**NOT FOR CONSTRUCTION**

|                     |       |      |
|---------------------|-------|------|
| Issued / Revisions: | Appd. | Date |
|                     |       |      |
|                     |       |      |
|                     |       |      |
|                     |       |      |

Client:




Project:  
**Storage Facility**  
 Country Club Rd.  
 Winston-Salem, NC

Title:


**ENLARGED PLUMBING PLANS**

Date:  
 Project No.:  
 Drawn by:  
 Sheet:

P-201

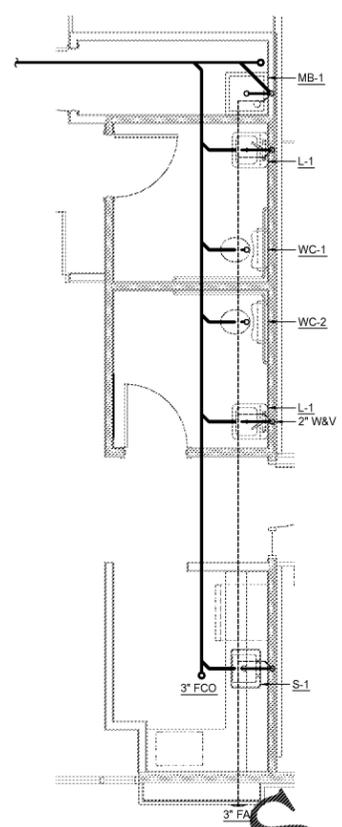

1 WASTE & VENT PLAN  
 P-201 SCALE: 1/8" = 1'-0"

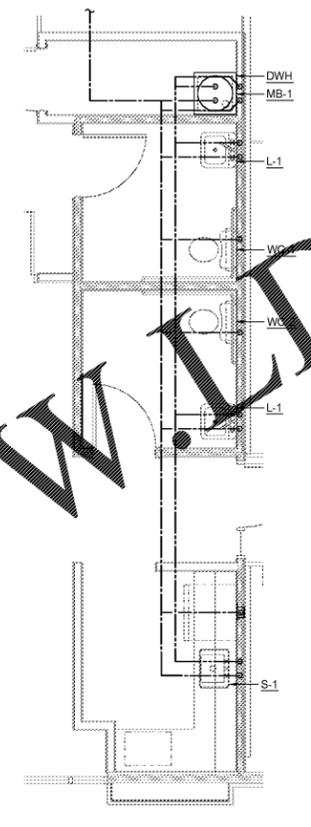

2 WATER & GAS PLAN  
 P-201 SCALE: 1/8" = 1'-0"

Order Plans @ WWW.LDILine.com